
				⁺ 0.0	⁺ 0.0	⁺ 0.0	⁺ 0.0	⁺ 0.0	⁺ 0.1	⁺ 0.1	⁺ 0.1	⁺ 0.1	⁺ 0.1	⁺ 0.1	⁺ 0.1	⁺ 0.1	⁺ 0.0	⁺ 0.0	+ 0.0	0.0	⁺ 0.0					
			⁺ 0.0	⁺ 0.0	⁺ 0.0	⁺ 0.1	⁺ 0.1	⁺ 0.1	⁺ 0.1	⁺ 0.1	⁺ 0.1	⁺ 0.1	⁺ 0.1	⁺ 0.1	⁺ 0.1	⁺ 0.1	⁺ 0.1	⁺ 0.1	⁺ 0.0	0.0	0.0	⁺ 0.0		APPR	OXIMATE	
		⁺ 0.0	⁺ 0.0	⁺ 0.0	⁺ 0.1	⁺ 0.1	⁺ 0.1	⁺ 0.1	⁺ 0.2	⁺ 0.2	⁺ 0.2	⁺ 0.2	⁺ 0.2	⁺ 0.2	⁺ 0.2	⁺ 0.1	⁺ 0.1	⁺ 0.1	⁺ 0.1	⁺ 0.0	⁺ 0.0	⁺ 0.0			ERTY LINE	
	⁺ 0.0	⁺ 0.0	⁺ 0.0	⁺ 0.1	⁺ 0.1	⁺ 0.1	⁺ 0.2	⁺ 0.3	⁺ 0.3	⁺ 0.4	⁺ 0.4	⁺ 0.4	⁺ 0.4	⁺ 0.4	⁺ 0.3	⁺ 0.3	⁺ 0.2	⁺ 0.1	⁺ 0.1	⁺ 0.1	⁺ 0.0	⁺ 0.0	⁺ 0.0			
	⁺ 0.0	⁺ 0.0	⁺ 0.0	⁺ 0.1	⁺ 0.2	⁺ 0.3	⁺ 0.4	⁺ 0.6	⁺ 0.7	⁺ 0.8	⁺ 0.9	⁺ 1.0	⁺ 1.0	⁺ 0.9	⁺ 0.8	⁺ 0.6	⁺ 0.5	⁺ 0.3	⁺ 0.2	⁺ 0.1	⁺ 0.1	⁺ 0.0	0 ,0	⁺ 0.0		
⁺ 0.0	⁺ 0.0	⁺ 0.0	⁺ 0.1	⁺ 0.1	⁺ 0.2	⁺ 0.6	⁺ 1.2	⁺ 1.9	⁺ 2.3	⁺ 2.5	+ 7 7	⁺ 2.9	⁺ 3.0	+ 2 0	⁺ 2.6	⁺ 2.0	⁺ 1.2	⁺ 0.6	⁺ 0.3	⁺ 0.1	⁺ 0.1	⁺ 0.0	⁺ 0.0	⁺ 0.0		
0.0	0.0	0.0	0.1	0.1	0.2	0.0	1.2	1.9	2.3	2.0	2.1	2.9	3.0	2.9	2.0	2.0	1.2	0.0	0.5	0.1	0.1	0.0	0.0	0.0		
⁺ 0.0	⁺ 0.0	⁺ 0.0	⁺ 0.1	⁺ 0.2	⁺ 0.4	⁺ 1.2	⁺ 3.8	1 [†] .1 C1	2 [⁺] 8.4 C1				5 ¹ 0.5 C₀1 ∘	6 ¹ 0.3 ©1	7 ^{⁺9.5} C1	8 [⁺] 7.5 C1	⁺ 3.9	⁺ 1.2	⁺ 0.4	⁺ 0.2	⁺ 0.1	⁺ 0.0	⁺ 0.0	⁺ 0.0		
⁺ 0.0	⁺ 0.0	⁺ 0.1	⁺ 0.1	⁺ 0.2	⁺ 0.6	⁺ 2.2	+		19 ¹ 19	20 + 20 = 20		$2^{+}24^{+}24^{+}24^{+}24^{+}$						⁺ 2.2	⁺ 0.6	⁺ 0.2	⁺ 0.1	⁺ 0.1	⁺ 0.0	⁺ 0.0		
⁺ 0.0	⁺ 0.0	⁺ 0.1	⁺ 0.1	⁺ 0.2	⁺ 0.7	⁺ 2.5	+	15 17	⁺ 21 ⁺ 23	3 ⁺ 23 ⁺ 22		4 ⁺ 28 ° ⁺ 28		9 28 2	27 24	18 ⁺ 15		⁺ 2.5	⁺ 0.7	⁺ 0.2	⁺ 0.1	⁺ 0.1	⁺ 0.0	⁺ 0.0		
⁺ 0.0	⁺ 0.0	⁺ 0.1	⁺ 0.1	⁺ 0.2	⁺ 0.5	⁺ 1.9	+	14 18 ⁺ 20 11 ⁺ 14 ⁺ 15	⁺ 16 ⁺ 16	I ⁺ 21 2 3	3 23 2 5 18 1		z		7 ⁺ 17 ⁺ 16			⁺ 1.9	⁺ 0.6	⁺ 0.2	⁺ 0.1	⁺ 0.1	⁺ 0.0	⁺ 0.0		
+	+	+0.0	+	+	+	+ 0	+	16 C1 [⁺] 4.4	15 C1 [⁺] 5.3	14 C1	+ C	+		11 C1 5.0	10 C1 ⁻5.6	9 C1 ⁺4.5	+	+	+	+	+0.4	+	+	+		
0.0	0.0	0.0	0.1	0.2	0.4	1.0	2.4	4.4	5.3	5.6	6.0	5.9 ° °		0.0	5.0	4.5	2.4	1.0	0.4	0.2	0.1	0.0	0.0	0.0		
⁺ 0.0	⁺ 0.0	⁺ 0.0	⁺ 0.1	⁺ 0.1	⁺ 0.2	⁺ 0.4	⁺ 0.8	⁺ 1.2	⁺ 1.4	⁺ 1.6	⁺ 1.7	⁺ 1.5	°+ 0.2	° ⁺ 1.2	⁺ 1.4	⁺ 1.2	⁺ 0.8	⁺ 0.4	⁺ 0.2	⁺ 0.1	⁺ 0.1	⁺ 0.0	⁺ 0.0	⁺ 0.0		
	⁺ 0.0	⁺ 0.0	⁺ 0.0	⁺ 0.1	⁺ 0.1	⁺ 0.2	⁺ 0.3	⁺ 0.4	⁺ 0.5	⁺ 0.6	⁺ 0.5	⁺ 0.5	⁺ 0.3	⁺ 0.4	⁺ 0.4	⁺ 0.4	⁺ 0.3	⁺ 0.2	⁺ 0.1	⁺ 0.1	⁺ 0.0	⁺ 0.0	⁺ 0.0			
	⁺ 0.0	⁺ 0.0	⁺ 0.0	⁺ 0.1	⁺ 0.1	⁺ 0.1	⁺ 0.2	⁺ 0.2	⁺ 0.2	⁺ 0.2	⁺ 0.2	⁺ 0.2	⁺ 0.2	⁺ 0.2	⁺ 0.2	⁺ 0.2	⁺ 0.1	⁺ 0.1	⁺ 0.1							
		+	+	+	+	+	÷	÷	+	+	+	+	+	+	+	+	+	+	<u>т</u>	NOTE: CAN	OPY HEI	GHT = 15 F	T A.F.G.			
		⁺ 0.0	0.0	0.0	0.0	0.1	0.1	0.1	⁺ 0.1	0.1	0.1	0.1	0.1	0.1	0.1	0.1	0.1	⁺ 0.1	0.0							
			⁺ 0.0	⁺ 0.0	⁺ 0.0	⁺ 0.0	⁺ 0.1	⁺ 0.1	⁺ 0.1	⁺ 0.1	⁺ 0.1	⁺ 0.1	⁺ 0.1		FOOT LABEL		EVELS CA	ALCULATE	ED AT GRA	ADE USING		LUMEN VA AVG	LUES MAX	MIN	AVG/MIN	MAX/MIN
															BEYO	ND CANOP						0.71	10.5	0.0	N.A.	N.A.
					0.0	⁺ 0.0	⁺ 0.0	⁺ 0.0	⁺ 0.0	⁺ 0.0	⁺ 0.0	⁺ 0.0	⁺ 0.0			R CANOPY						20.73	29	11	1.88	2.64
LUMINAIF	KE SCHEI																									
SYMBOL		QTY	LABEL	ARRANG	EMENT	LUMENS	LLF	DIMMIN		N MULTIPL	IER BU	JG RATING	6	WATTS/I	UMINAIRE		TAL WAT	TS	MANUFA	ACTURER	(CATALOG	LOGIC			
		16	C1	SINGLE		8475	1.010	0.610			B3	-U0-G1		32.9		526	6.4		CREE, I	NC.	(CPY250-C-	08L-57K7-F	-UL-DM-XX-10	V (DIMMING S	ET AT 5.0 V)
													1													



DISCLAIMER ANY SITE PLAN(S), FLOOR PLAN(S), RENDERING(S), LIGHTING LAYOUT(S) AND PHOTOMETRIC PLAN(S) INCLUDING BUT NOT LIMITED TO ANY PROJECT(S) CREATED/PRODUCED BY RED LEONARD ASSOCIATES INC., ARE ONLY INTENDE FOR ILLUSTRATION AND QUOTING PURPOSES ONLY. RED LEONARD ASSOCIATES HAS THE RIGHT TO USE THIRD PARTY LASERS, SCANNERS, AND CAMERAS BUT ACTUAL PROJECT CONDITIONS, DIMENSIONS, AND ACCURACY OF MEASUREMENTS MAY DIFFER FROM THESE OR ANY PARAMETERS. RED LEONARD ASSOCIATES INC. ASSUMES NO LIABILITY FOR WHAT IS CREATED/PRODUCED IN THESE RECREATIONS. THIS INCLUDES BUT IS NOT LIMITED TO THE USE OF, INSTALLATION OF AND/OR INTEGRITY OF EXISTING BUILDING(S), SURROUNDING AREA FOR PRODUCT(S) SUCH AS EXISTING POLE(S), ANCHOR BOLT(S), BASE(S), ARCHITECTURAL AND SIGNAGE STRUCTURE(S), LANDSCAPING PLAN(S), LIGHTING PLAN(S), FIXTURE SELECTION(S) AND PLACEMENT, MATERIAL(S), COLOR ACCURACY, TEXTURE(S), AND ANYTHING ATTRIBUTED TO PHOTO REALISM THAT IS CREATED. FURTHERMORE, RED LEONARD ASSOCIATES INC., DOES NOT ASSUME LIABILITY WHATSOEVER FOR ANY PURCHASES MADE BY CLIENT BEFORE, DURING, OR AT THE CONCLUSION OF THE PUBLISHED WORK. THE CUSTOMER, ITS RELATIVE AFFILIATES, AS WELL AS ANY OTHER PERSON(S) IN VIEWING OF THIS PRODUCT IS RESPONSIBLE FOR VERIFYING COMPLIANCE WITH ANY BUT NOT LIMITED TO ALL CODES, PERMITS, RESTRICTIONS, INSTRUCTIONS, PURCHASES, AND INSTALLATIONS OF OBJECTS VIEWED

WITHIN THIS DOCUMENT(S) OR PROJECT(S). SYMBOLS ARE NOT DRAWN TO SCALE. SIZE IS FOR CLARITY PURPOSES ONLY. SIZES AND DIMENSIONS ARE APPROXIMATE, ACTUAL MEASUREMENTS MAY VARY. DRAWINGS ARE NOT INTENDED FOR ENGINEERING OR CONSTRUCTION USE. THIS DOCUMENT, ANY RED LEONARD DRAWING(S), OR PROJECT(S) IS NOT TO BE USED AND/OR INTENDED FOR ENGINEERING OR CONSTRUCTION PURPOSES, BUT FOR ILLUSTRATIVE PURPOSES ONLY. ANY LOCATIONS OF EMERGENCY LIGHTING SHOWN WERE PROVIDED BY OTHERS. RED LEONARD ASSOCIATES IS NOT RESPONSIBLE FOR INSUFFICIENT LIGHTING DURING AN EMERGENCY EVENT. ANY USE OF THIS DOCUMENTATION AND/OR OTHER ARTICLES PRODUCED BY RED LEONARD WITHOUT WRITTEN AUTHORIZATION FROM JAYME J. LEONARD IS STRICTLY PROHIBITED.


URER		CATALOG LOGIC										
CPY250-C			C-08L-57K7-F-UL-DM-XX-10V (DIMMING SET AT 5.0 V)									
NDED HE PING ITES R WED r	SCALE: 1" = 10' DWG SIZE: D	LAYOUT BY: JSG DATE: 5/17/24	PROJECT NAME: WEIS MARKET CLARKSBURG, MD DRAWING NUMBER: RL-9654-S1									

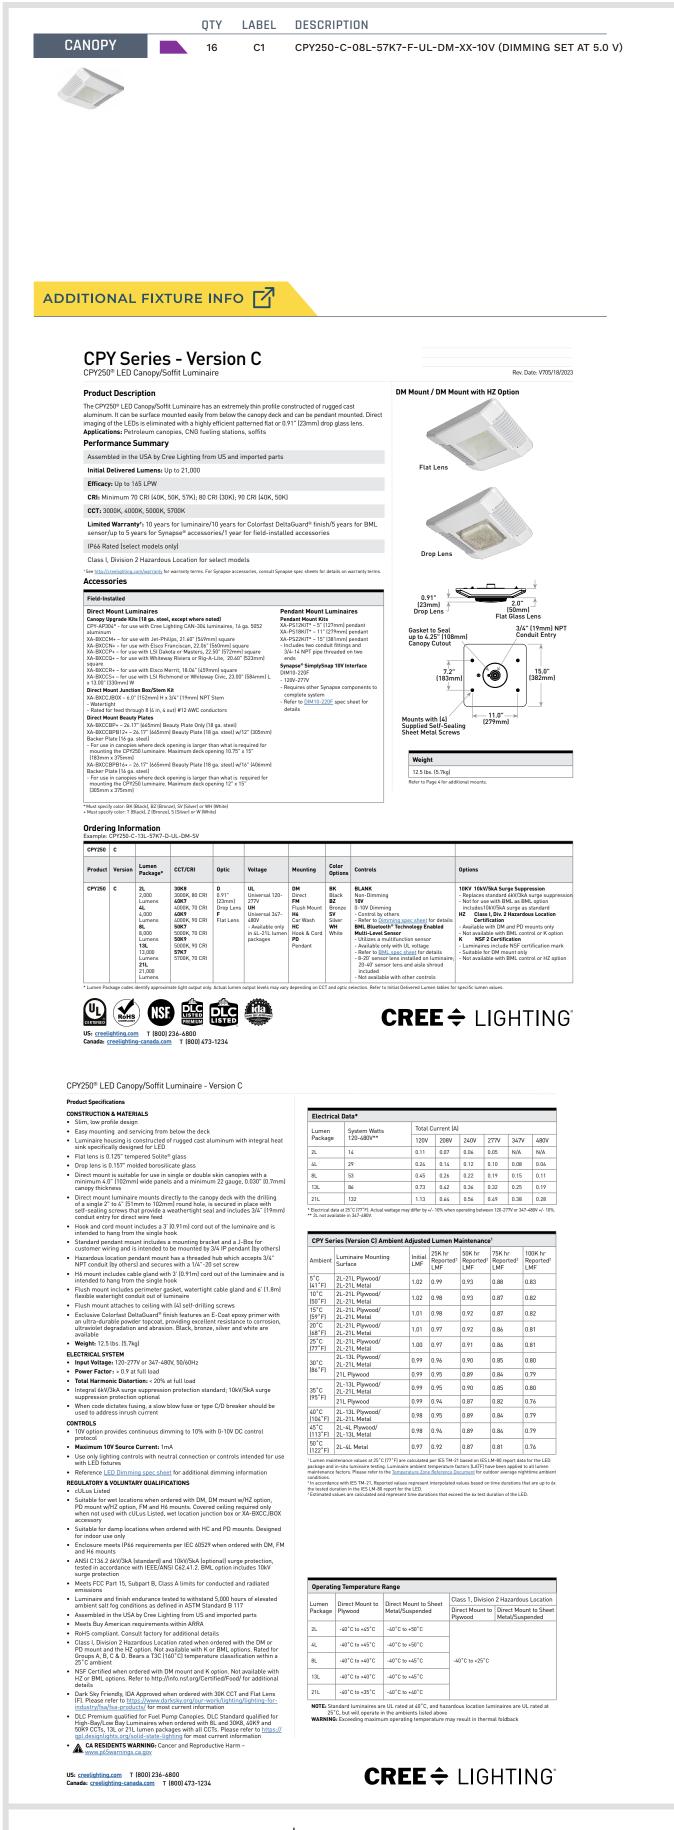



ANY SITE PLAN(S), FLOOR PLAN(S), RENDERING(S), LIGHTING LAYOUT(S) AND PHOTOMETRIC PLAN(S) INCLUDING BUT NOT LIMITED TO ANY PROJECT(S) CREATED/PRODUCED BY RED LEONARD ASSOCIATES INC., ARE ONLY INTENDED FOR ILLUSTRATION AND QUOTING PURPOSES ONLY. RED LEONARD ASSOCIATES HAS THE RIGHT TO USE THIRD PARTY LASERS, SCANNERS, AND CAMERAS BUT ACTUAL PROJECT CONDITIONS, DIMENSIONS, AND ACCURACY OF MEASUREMENTS MAY DIFFER FROM THESE OR ANY PARAMETERS. RED LEONARD ASSOCIATES INC. ASSUMES NO LIABILITY FOR WHAT IS CREATED/PRODUCED IN THESE RECREATIONS. THIS INCLUDES BUT IS NOT LIMITED TO THE USE OF, INSTALLATION OF AND/OR INTEGRITY OF EXISTING BUILDING(S), SURROUNDING AREA FOR PRODUCT(S) SUCH AS EXISTING POLE(S), ANCHOR BOLT(S), BASE(S), ARCHITECTURAL AND SIGNAGE STRUCTURE(S), LANDSCAPING PLAN(S), LIGHTING PLAN(S), FIXTURE SELECTION(S) AND PLACEMENT, MATERIAL(S), COLOR ACCURACY, TEXTURE(S), AND ANYTHING ATTRIBUTED TO PHOTO REALISM THAT IS CREATED, FURTHERMORE, RED LEONARD ASSOCIATES INC., DOES NOT ASSUME LIABILITY WHATSOEVER FOR ANY PURCHASES MADE BY CLIENT BEFORE, DURING, OR AT THE CONCLUSION OF THE PUBLISHED WORK. THE CUSTOMER, ITS RELATIVE AFFILIATES, AS WELL AS ANY OTHER PERSON(S) IN VIEWING OF THIS PRODUCT IS RESPONSIBLE FOR VERIFYING COMPLIANCE WITH ANY BUT NOT LIMITED TO ALL CODES, PERMITS, RESTRICTIONS, INSTRUCTIONS, PURCHASES, AND INSTALLATIONS OF OBJECTS VIEWED WITHIN THIS DOCUMENT(S) OR PROJECT(S). SYMBOLS ARE NOT DRAWN TO SCALE. SIZE IS FOR CLARITY PURPOSES ONLY. SIZES AND DIMENSIONS ARE APPROXIMATE, ACTUAL MEASUREMENTS MAY VARY. DRAWINGS ARE NOT INTENDED FOR ENGINEERING OR CONSTRUCTION USE. THIS DOCUMENT, ANY RED LEONARD DRAWING(S), OR PROJECT(S) IS NOT TO BE USED AND/OR INTENDED FOR ENGINEERING OR CONSTRUCTION PURPOSES, BUT FOR ILLUSTRATIVE PURPOSES ONLY. ANY USE OF THIS DOCUMENTATION AND/OR OTHER ARTICLES PRODUCED BY RED LEONARD WITHOUT WRITTEN AUTHORIZATION FROM JAYME J. LEONARD IS STRICTLY PROHIBITED.

PROJECT NAME: WEIS MARKET CLARKSBURG, MD DRAWING NUMBER: RL-9654-S1

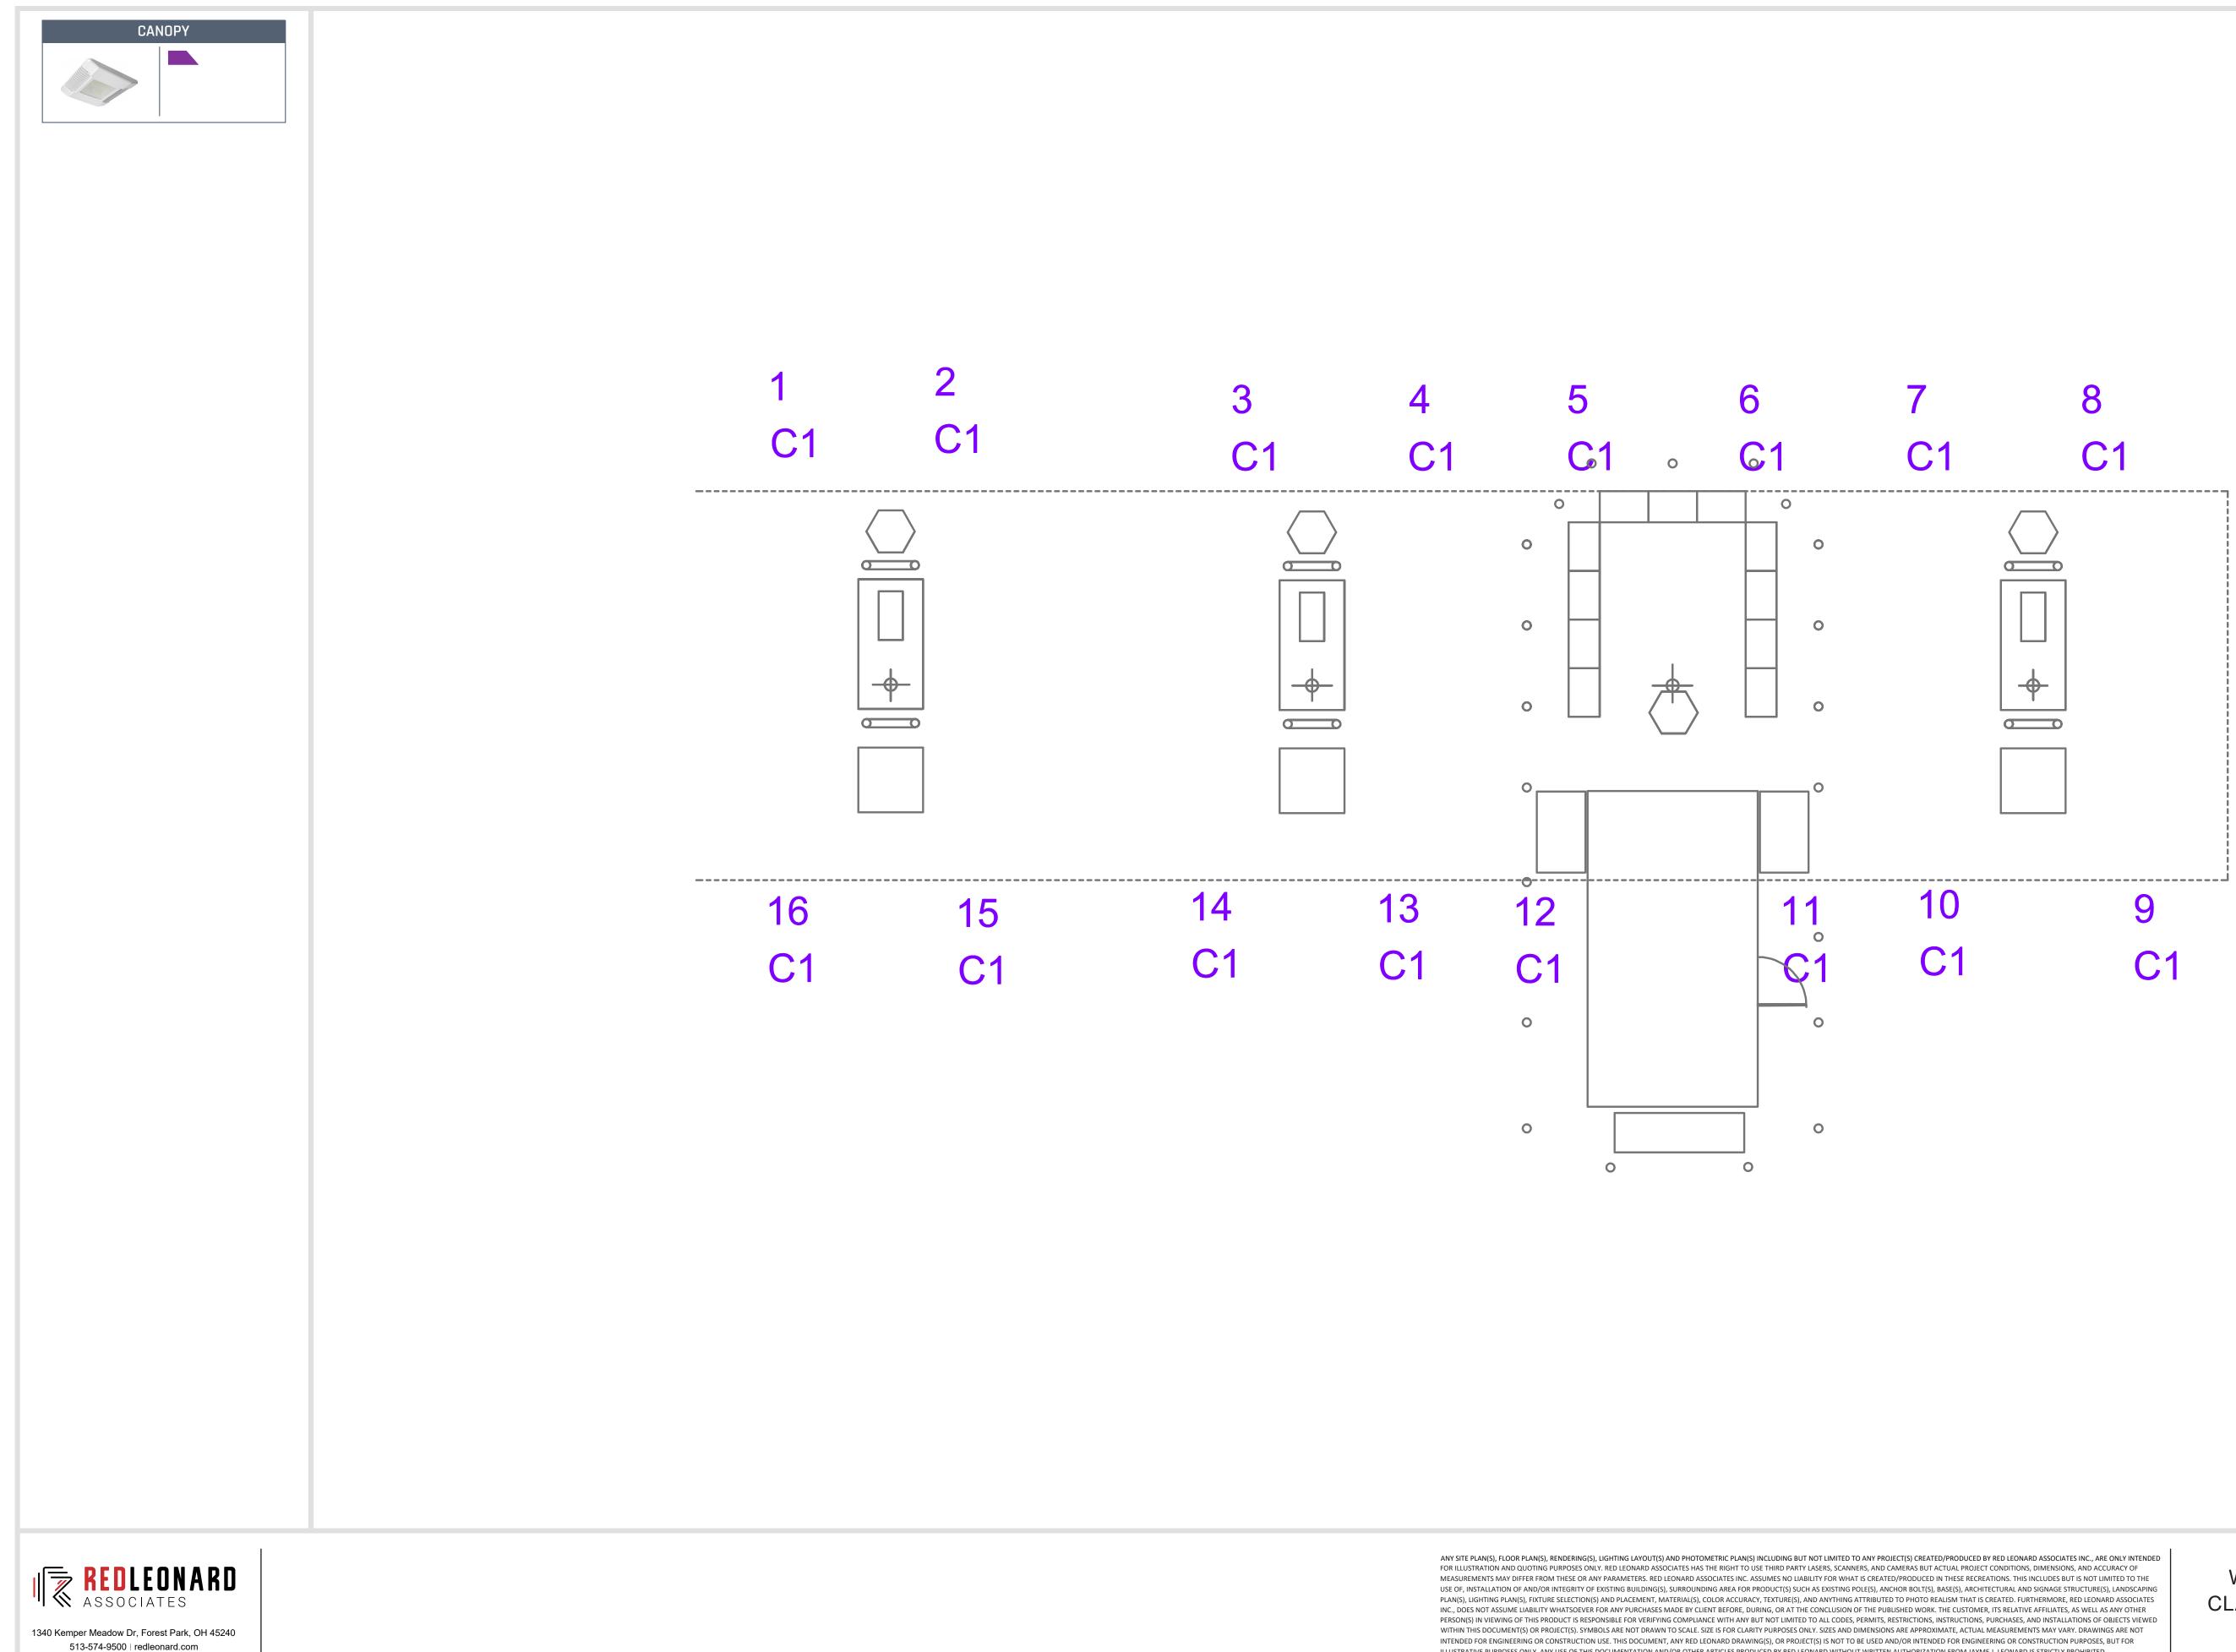

ILLUSTRATIVE PURPOSES ONLY. ANY USE OF THIS DOCUMENTATION AND/OR OTHER ARTICLES PRODUCED BY RED LEONARD WITHOUT WRITTEN AUTHORIZATION FROM JAYME J. LEONARD IS STRICTLY PROHIBITED.

PROJECT NAME: WEIS MARKET CLARKSBURG, MD DRAWING NUMBER: RL-9654-S1