

LANDSCAPING AND PARKING LOT LIGHT IMAGES TAKEN BETWEEN 6:30PM-6:45PM

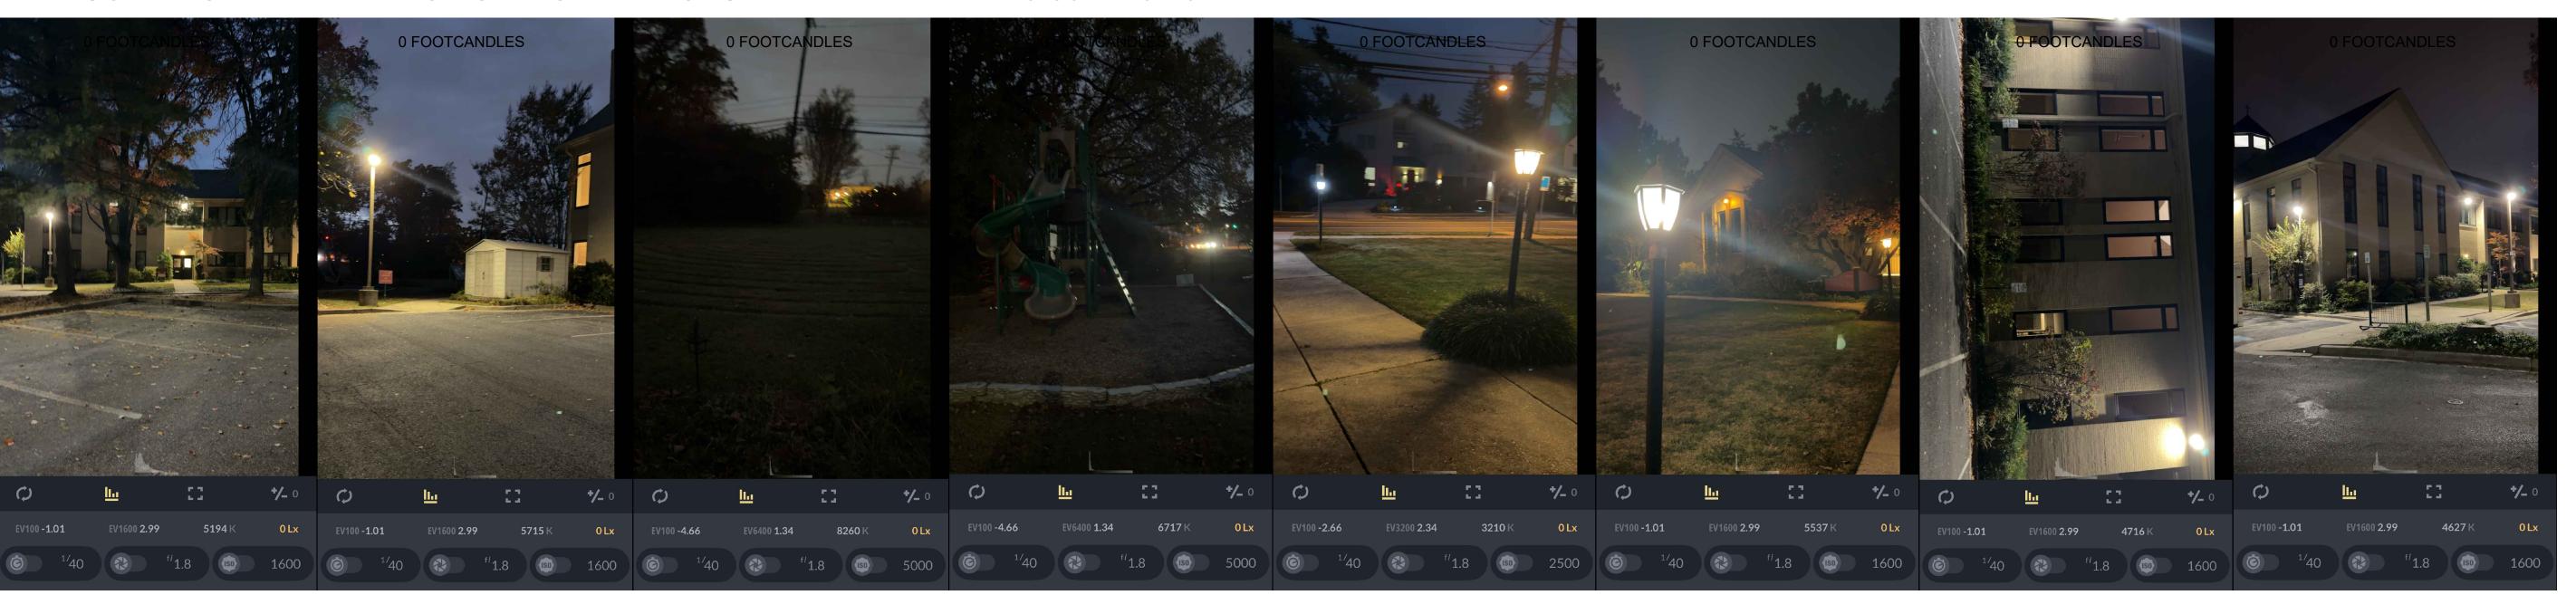



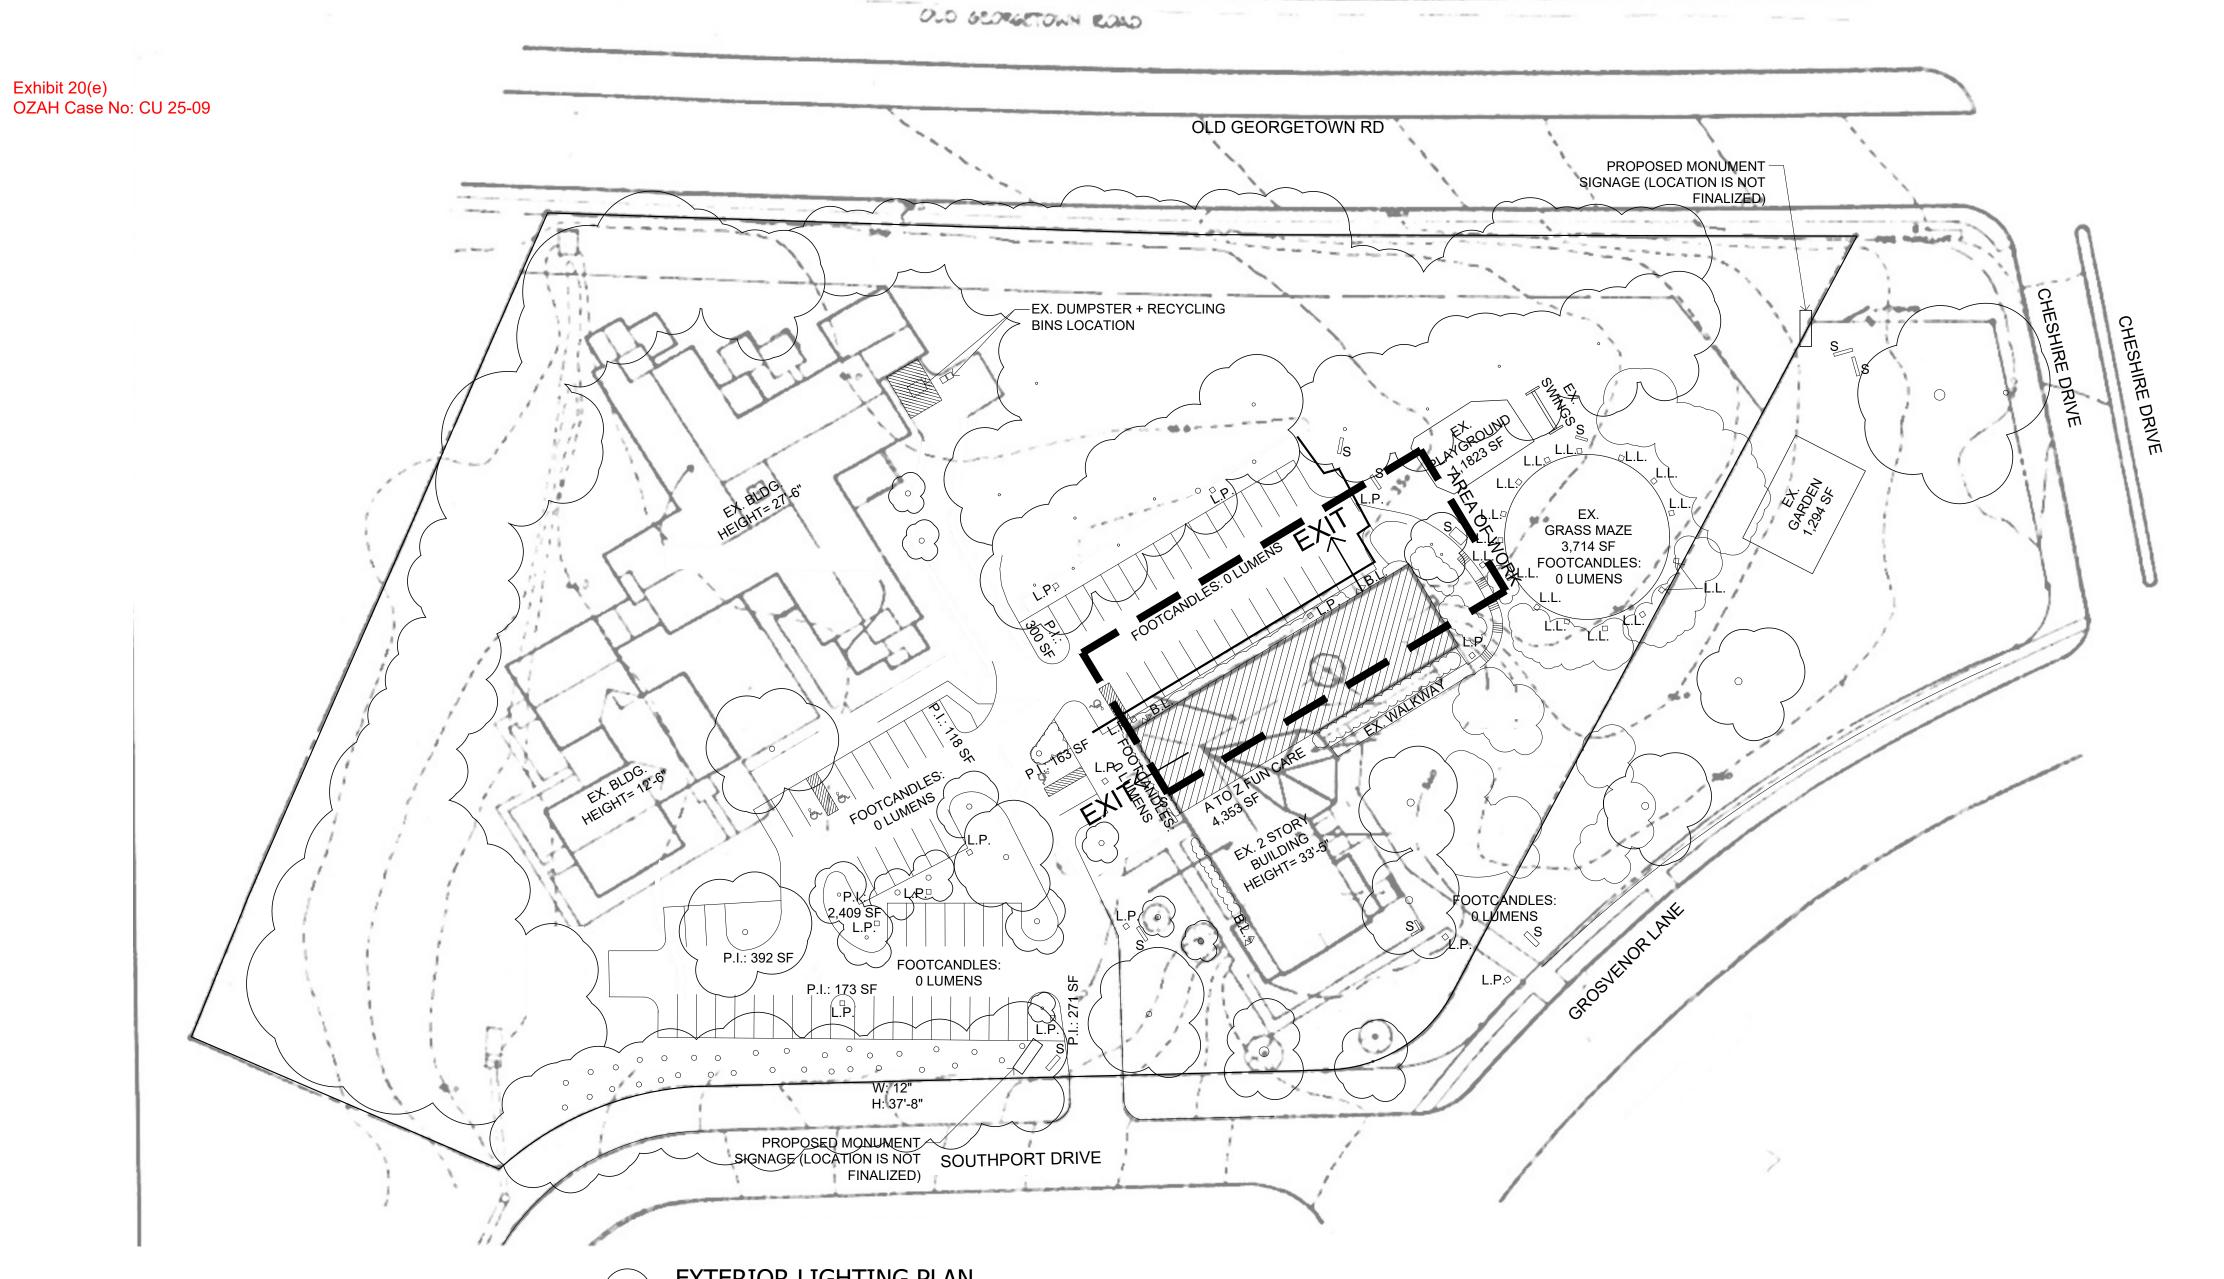



ARCHITECTS

3G ARCHITECTS, LLC.

1749 OLD MEADOW ROAD
SUITE 506
MCLEAN, VA 22102
703-506-6868
3GARCHITECTS.COM

Professional Certification; I certify that these documents were prepared or approved by me, and that I am a duly licensed architect under the laws of the State of Maryland, Licence number 12387, Expiration date: 3-30-2026.

Consultants

DAYCARE CENTER

6030 GROSVENOR LN BETHESDA, MD 20814


A TO Z FUN CARE

Drawings

EXTERIOR LIGHTING PLAN

DATE |ISSUE 01/20/25 FCP EXEMPTION
02/12/25 CONDITIONAL USE
03/27/25 INTAKE COMMENTS
05/16/25 AGENCY COMMENT
06/04/25 AGENCY COMMENT
08/25/25 AGENCY COMMENT
10/27/25 OZAH COMMENT

E-SIG

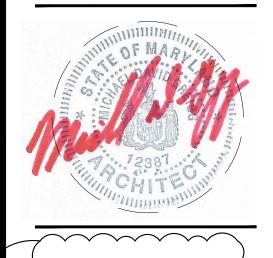

EXTERIOR LIGHTING PLAN SCALE:1:40